


SECTION A
CONCRETE FOUNDATION

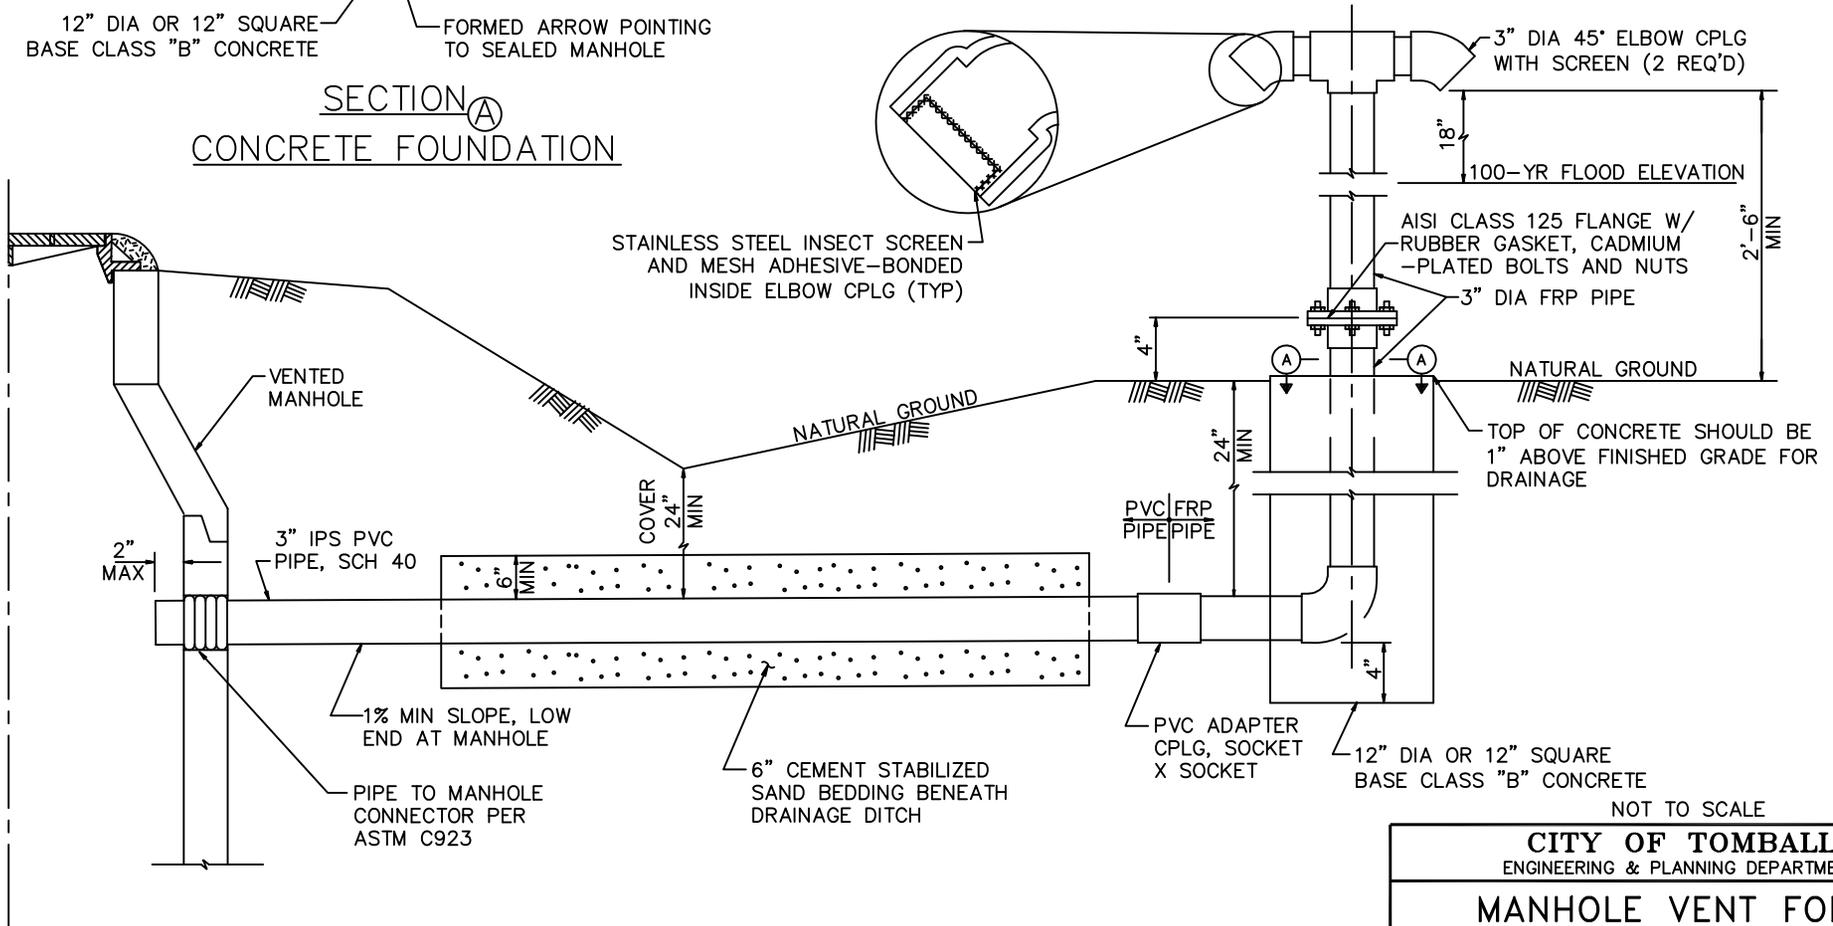

NOTES:

1. INSTALL AT LOCATION BASED ON 100-YEAR FLOOD ELEVATION SHOWN ON PLAN AND PROFILE DWGS.
2. DRAIN TO VENTED (ADJACENT) MH AT MIN 1% SLOPE. CONNECT TO MANHOLE WITH SPECIFIED CONNECTOR.
3. WHEN VENT CROSSES DRAINAGE DITCH, PROVIDE CEMENT STABILIZED SAND BEDDING.
4. THE VENT IS TO BE INSTALLED WITHIN THE RIGHT OF WAY.
5. SEE STANDARD SPECIFICATION FOR PROTECTIVE COATING REQUIREMENTS FOR EXPOSED FRP PIPE.

NOT TO SCALE

CITY OF TOMBALL ENGINEERING & PLANNING DEPARTMENT	
MANHOLE VENT FOR SEALED MANHOLE	
APPROVED BY COT:	
ENGINEERING & PLANNING DEPARTMENT EFFECTIVE JULY 1, 2010	
SHEET 001 OF 001	DWG NO: COT WW-12